




LOBE & ASSOCIATES, INC.

1314 5th Avenue North, Suite 200
Nashville, Tennessee 37208
(615) 242-0040


220 West Oregon Street, Suite 100
Lawrenceville, Georgia 30046
(770) 338-0017

www.lobeassoc.com


THIS DRAWING AND THE DESIGN THEREON IS THE PROPERTY OF THE ARCHITECT. REPRODUCTION, COPYING, OR USE OF THE DRAWING WITHOUT THEIR WRITTEN CONSENT IS PROHIBITED. AND ANY VIOLATION IS SUBJECT TO LEGAL ACTION.

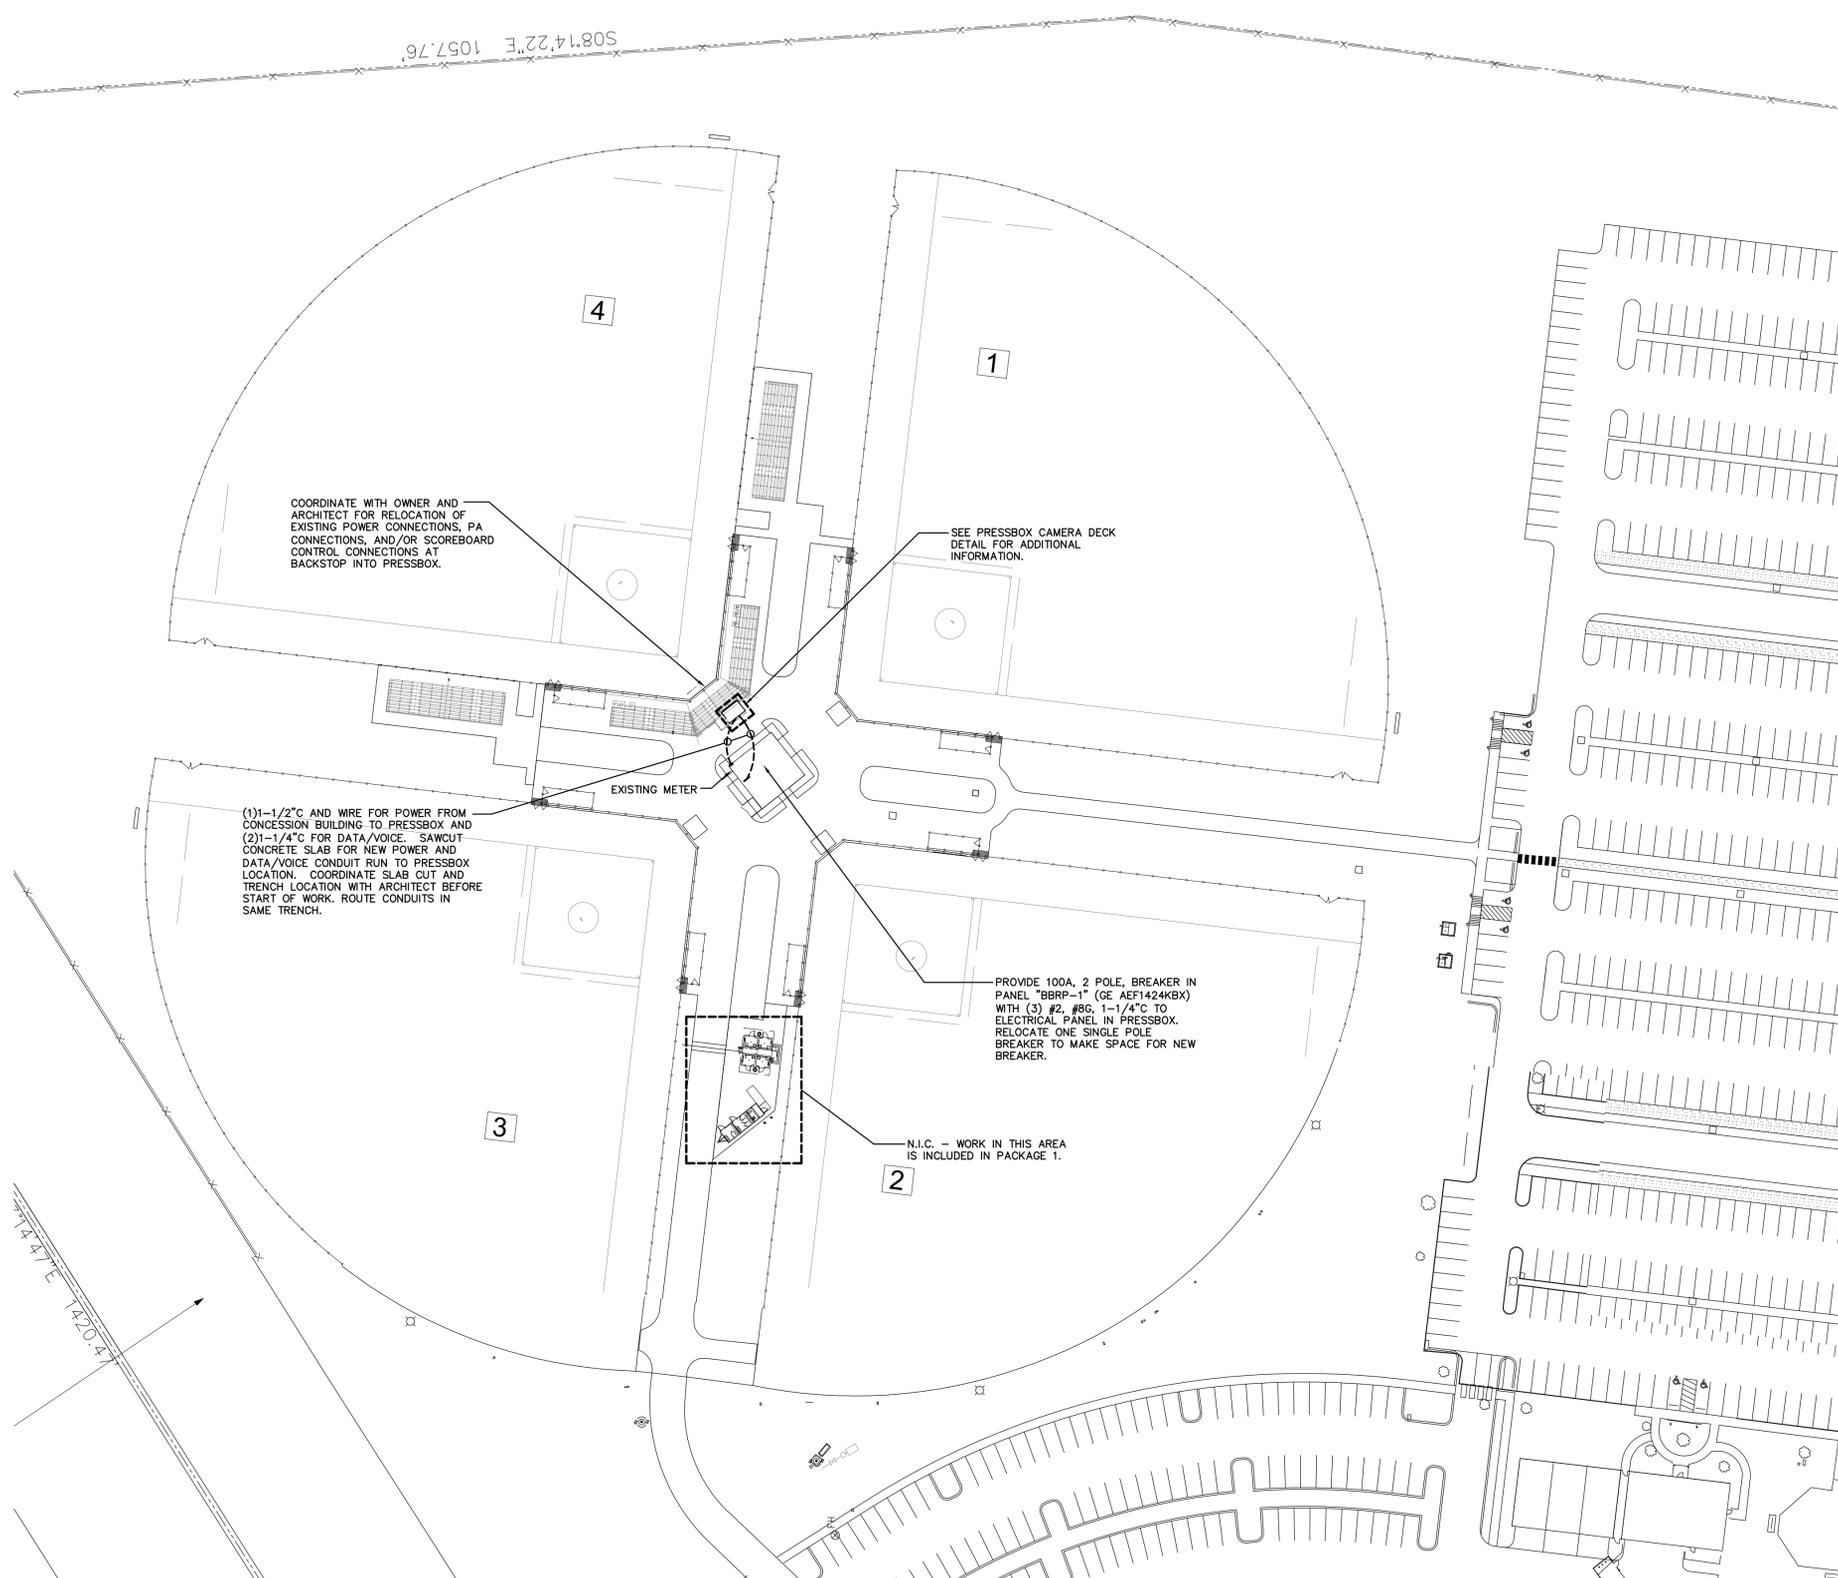


SITE ELECTRICAL PLAN
SCALE: 50" = 1'-0"

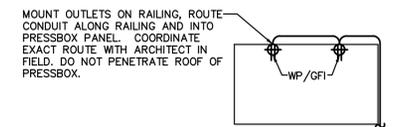

PRESSBOX CAMERA DECK DETAIL
NO SCALE

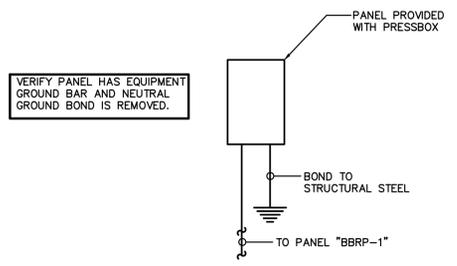

ELECTRICAL RISER DIAGRAM - PRESSBOX
NO SCALE
NOTE: COPPER CONDUCTORS UNLESS NOTED OTHERWISE

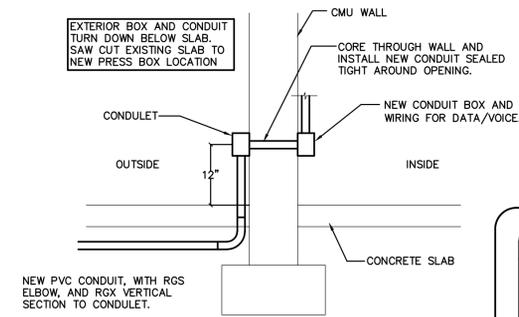

DATA & POWER THRU EXTERIOR WALL DETAIL
SCALE: NONE

RIDLEY PARK SPORTS COMPLEX EXPANSION
SOFTBALL BLEACHERS - PACKAGE 2

TENNESSEE

PREPARED FOR:
CITY OF COLUMBIA

COLUMBIA

REVISIONS		
NO.	DATE	COMMENTS

SHEET TITLE

SITE ELECTRICAL PLAN

PROJECT NO. 15219	DATE 08/11/2016
DRAWN BY JKM	SCALE AS SHOWN
CHECKED BY AJP	SHEET NO.

E1.0

