


| | | | | | | | | | | | | | |
|--|---|----------------|-------------|------------------|-----------|----------|-------------------------------------|-------------------|---|--------|---|--------|---|
|  <p>1214 Church Street Nashville, TN 37246 (615) 747-3970 www.nespower.com Attachments@nespower.com</p> | <p>N ↑</p> <p>Overview Map</p> | Design Date: | 11/20/2017 | Reviewed By: | C.Duncan | OK Poles | <input checked="" type="checkbox"/> | Utility: | 1 | Other: | 0 | Total: | 1 |
| | | Design By: | C.Duncan | Revise By: | | 1 | | | | | | | |
| | | Drawn By: | M.Greenwell | City / Township: | Nashville | | | | | | | | |
| | | Application #: | 17L-02220 | County: | Davidson | | | | | | | | |
| Proposee Code: | City of Belle Meade Video Surveillance System 1 | Line Dept: | WSC | ENG WO#: | 318540 | ENG WR#: | 991351431 | Pole Count | 1 | 0 | 1 | | |
| | | | | | | | | New Attachments | 1 | 0 | 1 | | |
| | | | | | | | | Overlash | 0 | 0 | 0 | | |
| | | | | | | | | Rearrangement | 0 | 0 | 0 | | |
| | | | | | | | | Midspan Poles | 0 | 0 | 0 | | |
| | | | | | | | | Pole Replacements | 0 | 0 | 0 | | |

Operator shall not install Attachments without having received a License for each pole. This Cover Map shall not be considered a License to Attach.
 Communications cables shall be no closer than 40" from utility conductors at pole and 30" at midspan.
 All Companies must tag attachments with approved permanent identification markers.

Drawing Title: E(P)PC = Existing (Proposed) Pole Clearance problem E (P)BC = Existing (Proposed) Between Clearance problem E(P)OL = Existing (Proposed) Pole Overload E(P)JH = Existing (Proposed) Attached to J-Hook E(P)TT = Existing (Proposed) Trim Trees
 E(P)GC = Existing (Proposed) Ground Clearance problem E(P)NA = Existing (Proposed) Not Attached to pole E(P)GA = Existing (Proposed) Guy / Anchor problem PPA= Proposed Cable already Attached PCA = Proposed Cannot attach

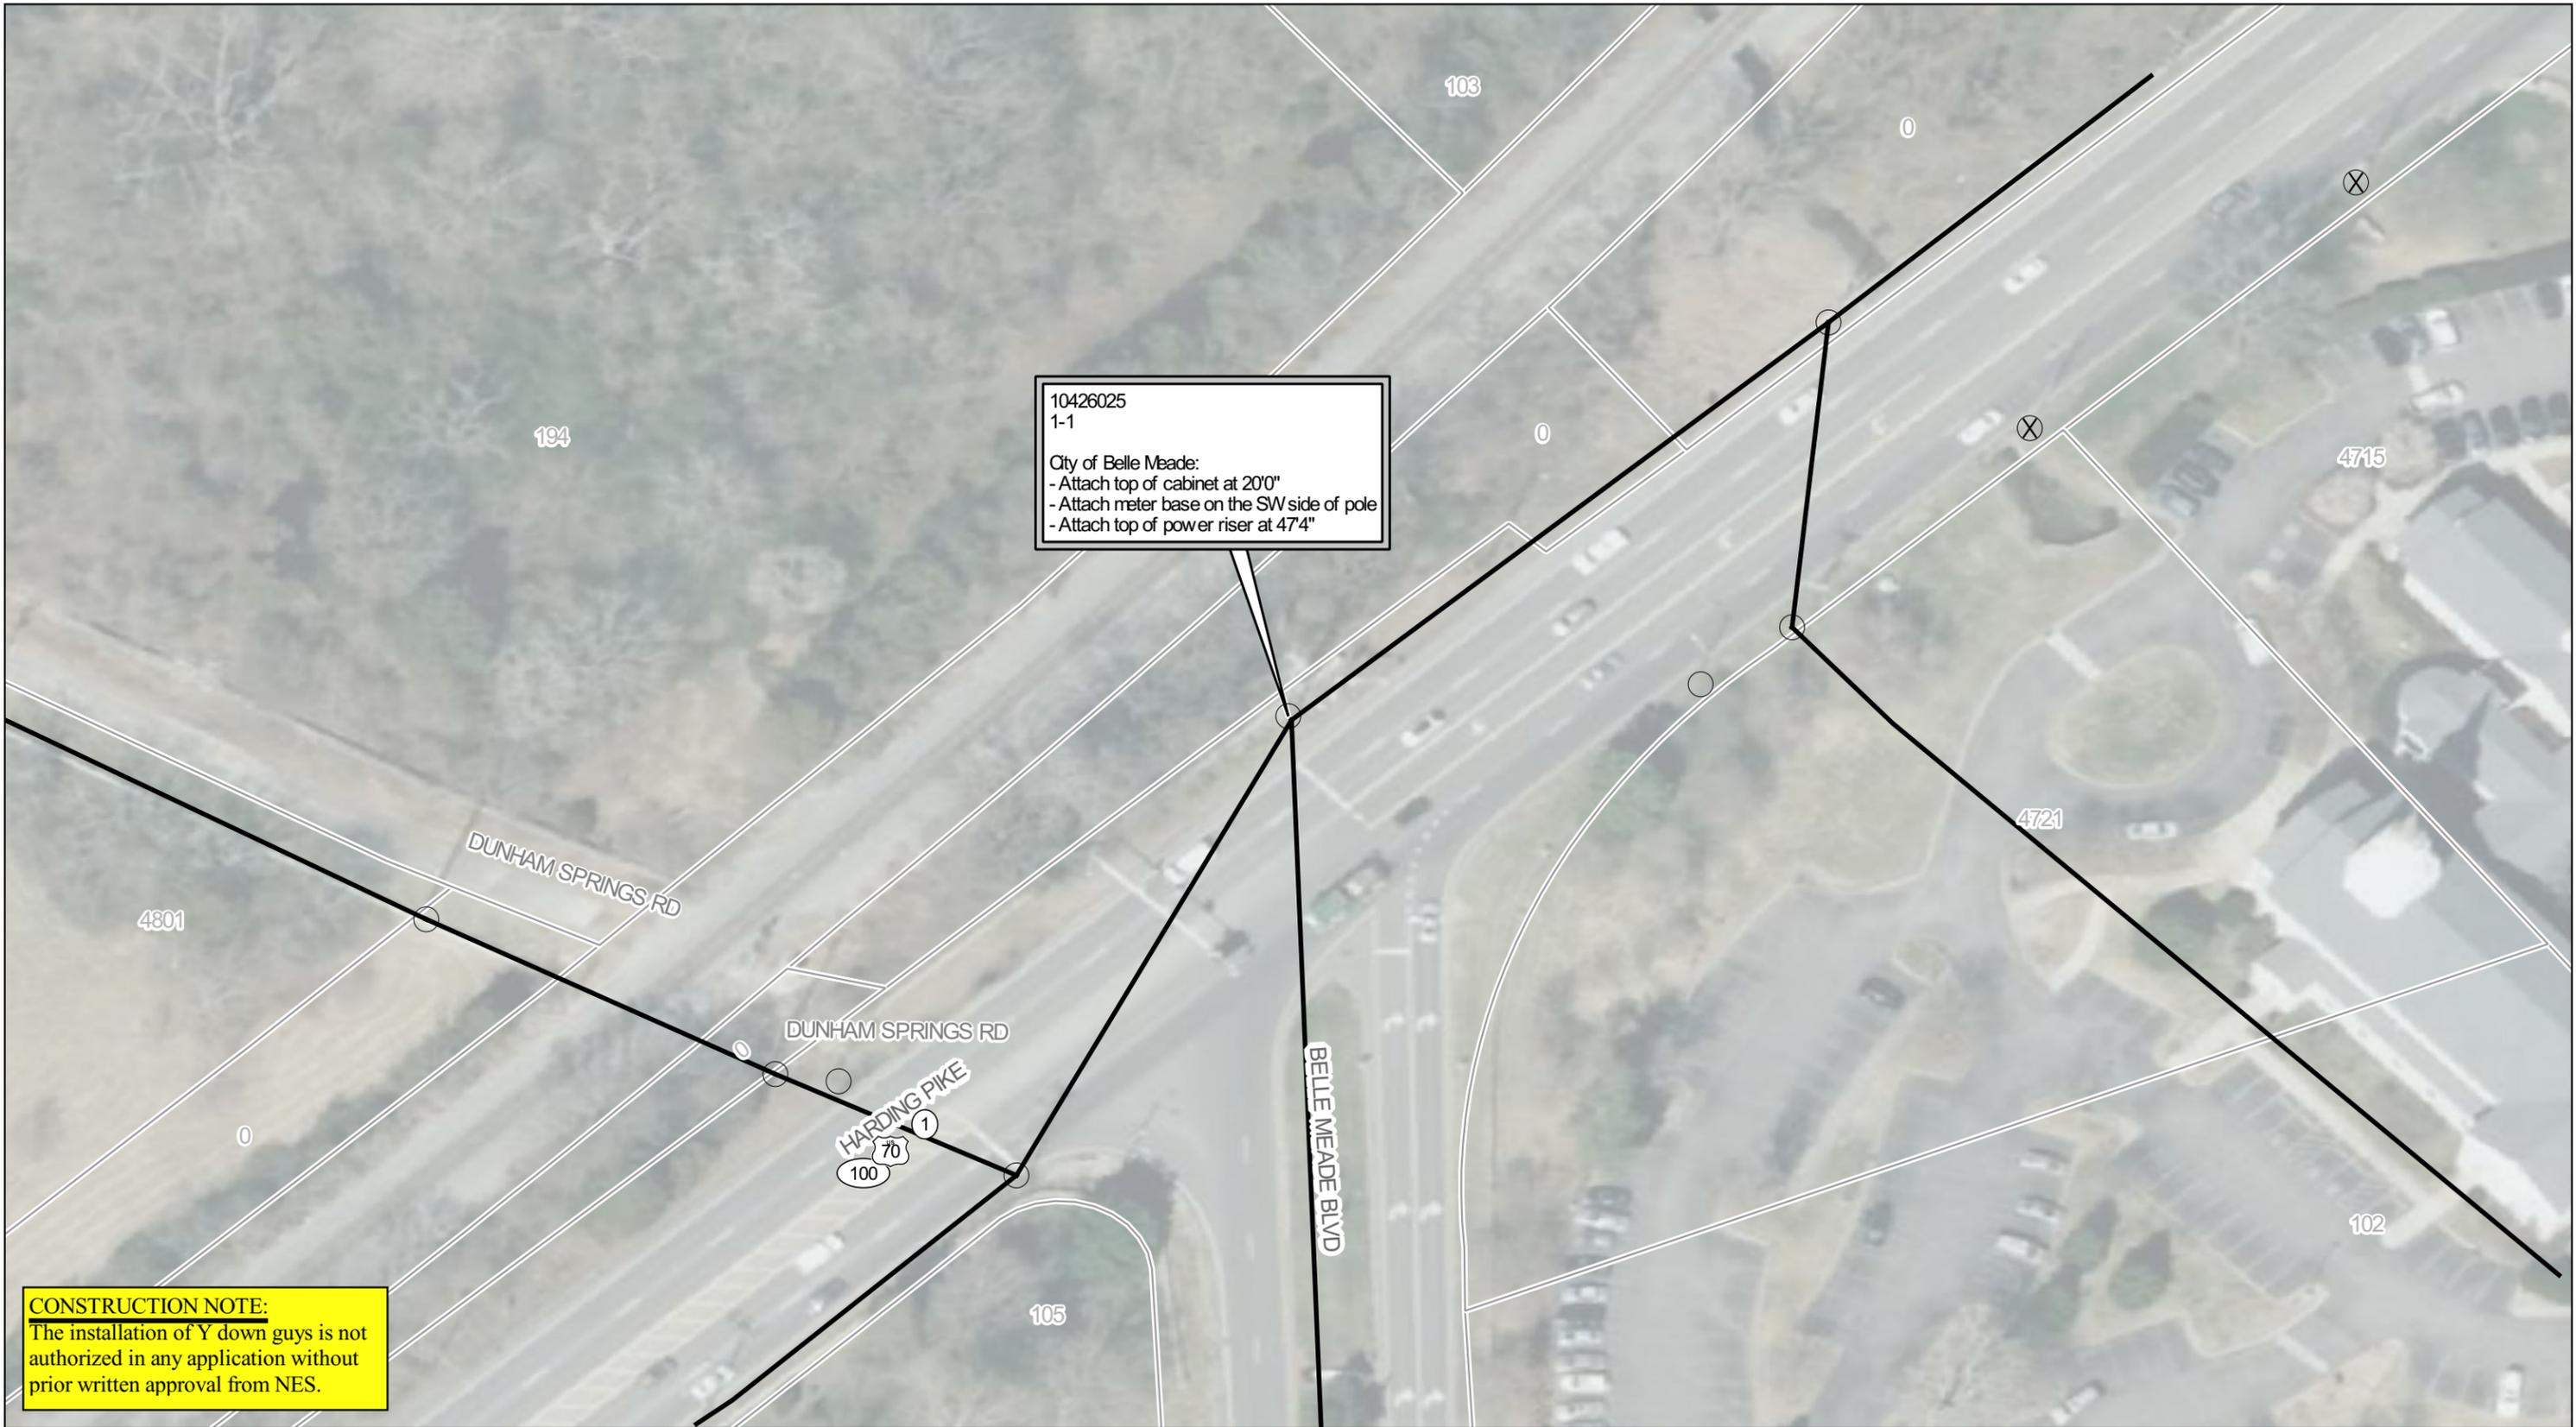

10426025
1-1
City of Belle Meade:
- Attach top of cabinet at 20'0"
- Attach meter base on the SW side of pole
- Attach top of power riser at 47'4"

CONSTRUCTION NOTE:
The installation of Y down guys is not authorized in any application without prior written approval from NES.

| | | | | | | | | | | | | | | | | | | | | | | | | | | | | | | | |
|--|---|------------------|------------|---|----------|----------|--|------------|--------|--|-----------|-----------------|----------|--------|--------|----------|---|---|---|---------------|---|---|---|---------------|---|---|---|-------------------|---|---|---|
|  1214 Church Street Nashville, TN 37246 (615) 747-3970 www.nespower.com Attachments@nespower.com |  Sheet 1 of 1 | Design Date: | 11/20/2017 | Reviewed By: | C.Duncan | OK Poles | | | | <table border="1"> <tr> <td>Utility:</td> <td>Other:</td> <td>Total:</td> </tr> <tr> <td>1</td> <td>0</td> <td>1</td> </tr> </table> | | | Utility: | Other: | Total: | 1 | 0 | 1 | | | | | | | | | | | | | |
| | | Utility: | Other: | Total: | | | | | | | | | | | | | | | | | | | | | | | | | | | |
| 1 | 0 | 1 | | | | | | | | | | | | | | | | | | | | | | | | | | | | | |
| Design By: | C.Duncan | Revise By: | | <table border="1"> <tr> <td>Pole Count</td> <td>1</td> <td>0</td> <td>1</td> </tr> <tr> <td>New Attachments</td> <td>1</td> <td>0</td> <td>1</td> </tr> <tr> <td>Overlash</td> <td>0</td> <td>0</td> <td>0</td> </tr> <tr> <td>Rearrangement</td> <td>0</td> <td>0</td> <td>0</td> </tr> <tr> <td>Midspan Poles</td> <td>0</td> <td>0</td> <td>0</td> </tr> <tr> <td>Pole Replacements</td> <td>0</td> <td>0</td> <td>0</td> </tr> </table> | | | | Pole Count | 1 | 0 | 1 | New Attachments | 1 | 0 | 1 | Overlash | 0 | 0 | 0 | Rearrangement | 0 | 0 | 0 | Midspan Poles | 0 | 0 | 0 | Pole Replacements | 0 | 0 | 0 |
| Pole Count | 1 | 0 | 1 | | | | | | | | | | | | | | | | | | | | | | | | | | | | |
| New Attachments | 1 | 0 | 1 | | | | | | | | | | | | | | | | | | | | | | | | | | | | |
| Overlash | 0 | 0 | 0 | | | | | | | | | | | | | | | | | | | | | | | | | | | | |
| Rearrangement | 0 | 0 | 0 | | | | | | | | | | | | | | | | | | | | | | | | | | | | |
| Midspan Poles | 0 | 0 | 0 | | | | | | | | | | | | | | | | | | | | | | | | | | | | |
| Pole Replacements | 0 | 0 | 0 | | | | | | | | | | | | | | | | | | | | | | | | | | | | |
| Drawn By: | M.Greenwell | City / Township: | Nashville | <table border="1"> <tr> <td>ENG WO#:</td> <td>318540</td> <td>ENG WR#:</td> <td>991351431</td> </tr> </table> | | | | ENG WO#: | 318540 | ENG WR#: | 991351431 | | | ENG WO#: | 318540 | ENG WR#: | 991351431 | | | | | | | | | | | | | | | | | | | | | | | | | | | | |
| Application #: | 17L-02220 | County: | Davidson | | | | | | | | | | | | | | | | | | | | | | | | | | | | |
| Proposee Code: | City of Belle Meade Video Surveillance System 1 | Line Dept: | WSC | | | | | | | | | | | | | | | | | | | | | | | | | | | | |

Operator shall not install Attachments without having received a License for each pole. This Cover Map shall not be considered a License to Attach.
 Communications cables shall be no closer than 40" from utility conductors at pole and 30" at midspan.
 All Companies must tag attachments with approved permanent identification markers.

Drawing Title: E(P)PC = Existing (Proposed) Pole Clearance problem E (P)BC = Existing (Proposed) Between Clearance problem E(P)OL = Existing (Proposed) Pole Overload E(P)JH = Existing (Proposed) Attached to J-Hook E(P)TT = Existing (Proposed) Trim Trees
 E(P)GC = Existing (Proposed) Ground Clearance problem E(P)NA = Existing (Proposed) Not Attached to pole E(P)GA = Existing (Proposed) Guy / Anchor problem PPA= Proposed Cable already Attached PCA = Proposed Cannot attach