


MIDWAY SEWAGE TREATMENT PLANT

FOR
ROANE COUNTY SCHOOLS

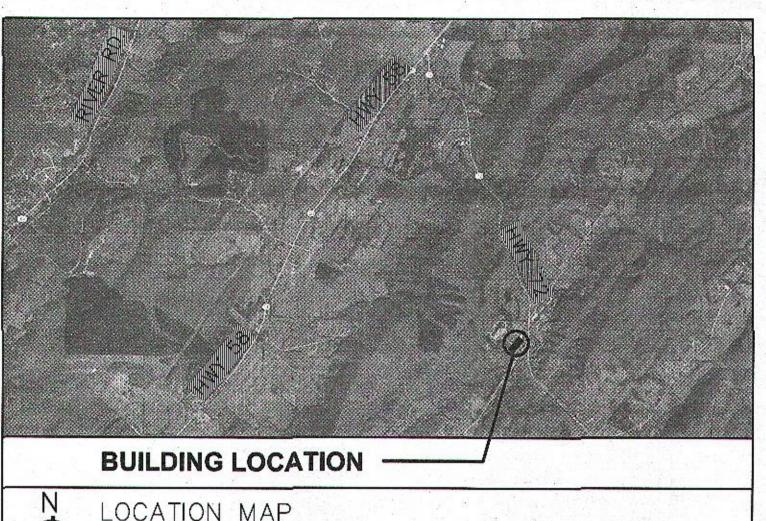

 $\frac{1}{\sqrt{1}}$

LOCATION MAP Midway High School 530 Loudon Hwy, Kingston, TN 37763

OWNER:
ROANE COUNTY SCHOOLS
530 Loudon Hwy., Kingston, TN 37763

DATE: DECEMBER 2, 2018

DRAWING INDEX:


COVER SHEET
P101 - FLOOR PLAN - PIPING
P201 - SPECIFICATIONS

DESIGNER:


ENGINEERING SERVICES GROUP, INC.


MECHANICAL & ELECTRICAL ENGINEERS 900 E. HILL AVE. SUITE 350 KNOXVILLE, TN 37915 PHONE: 865.522.0393 FAX: 865.522.0166

PROJECT MANAGER: RON DONAHUE EMAIL: rdonahue@esg1989.com

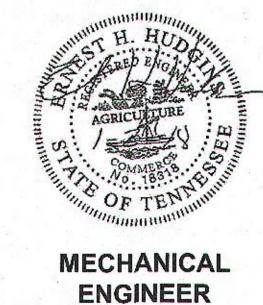




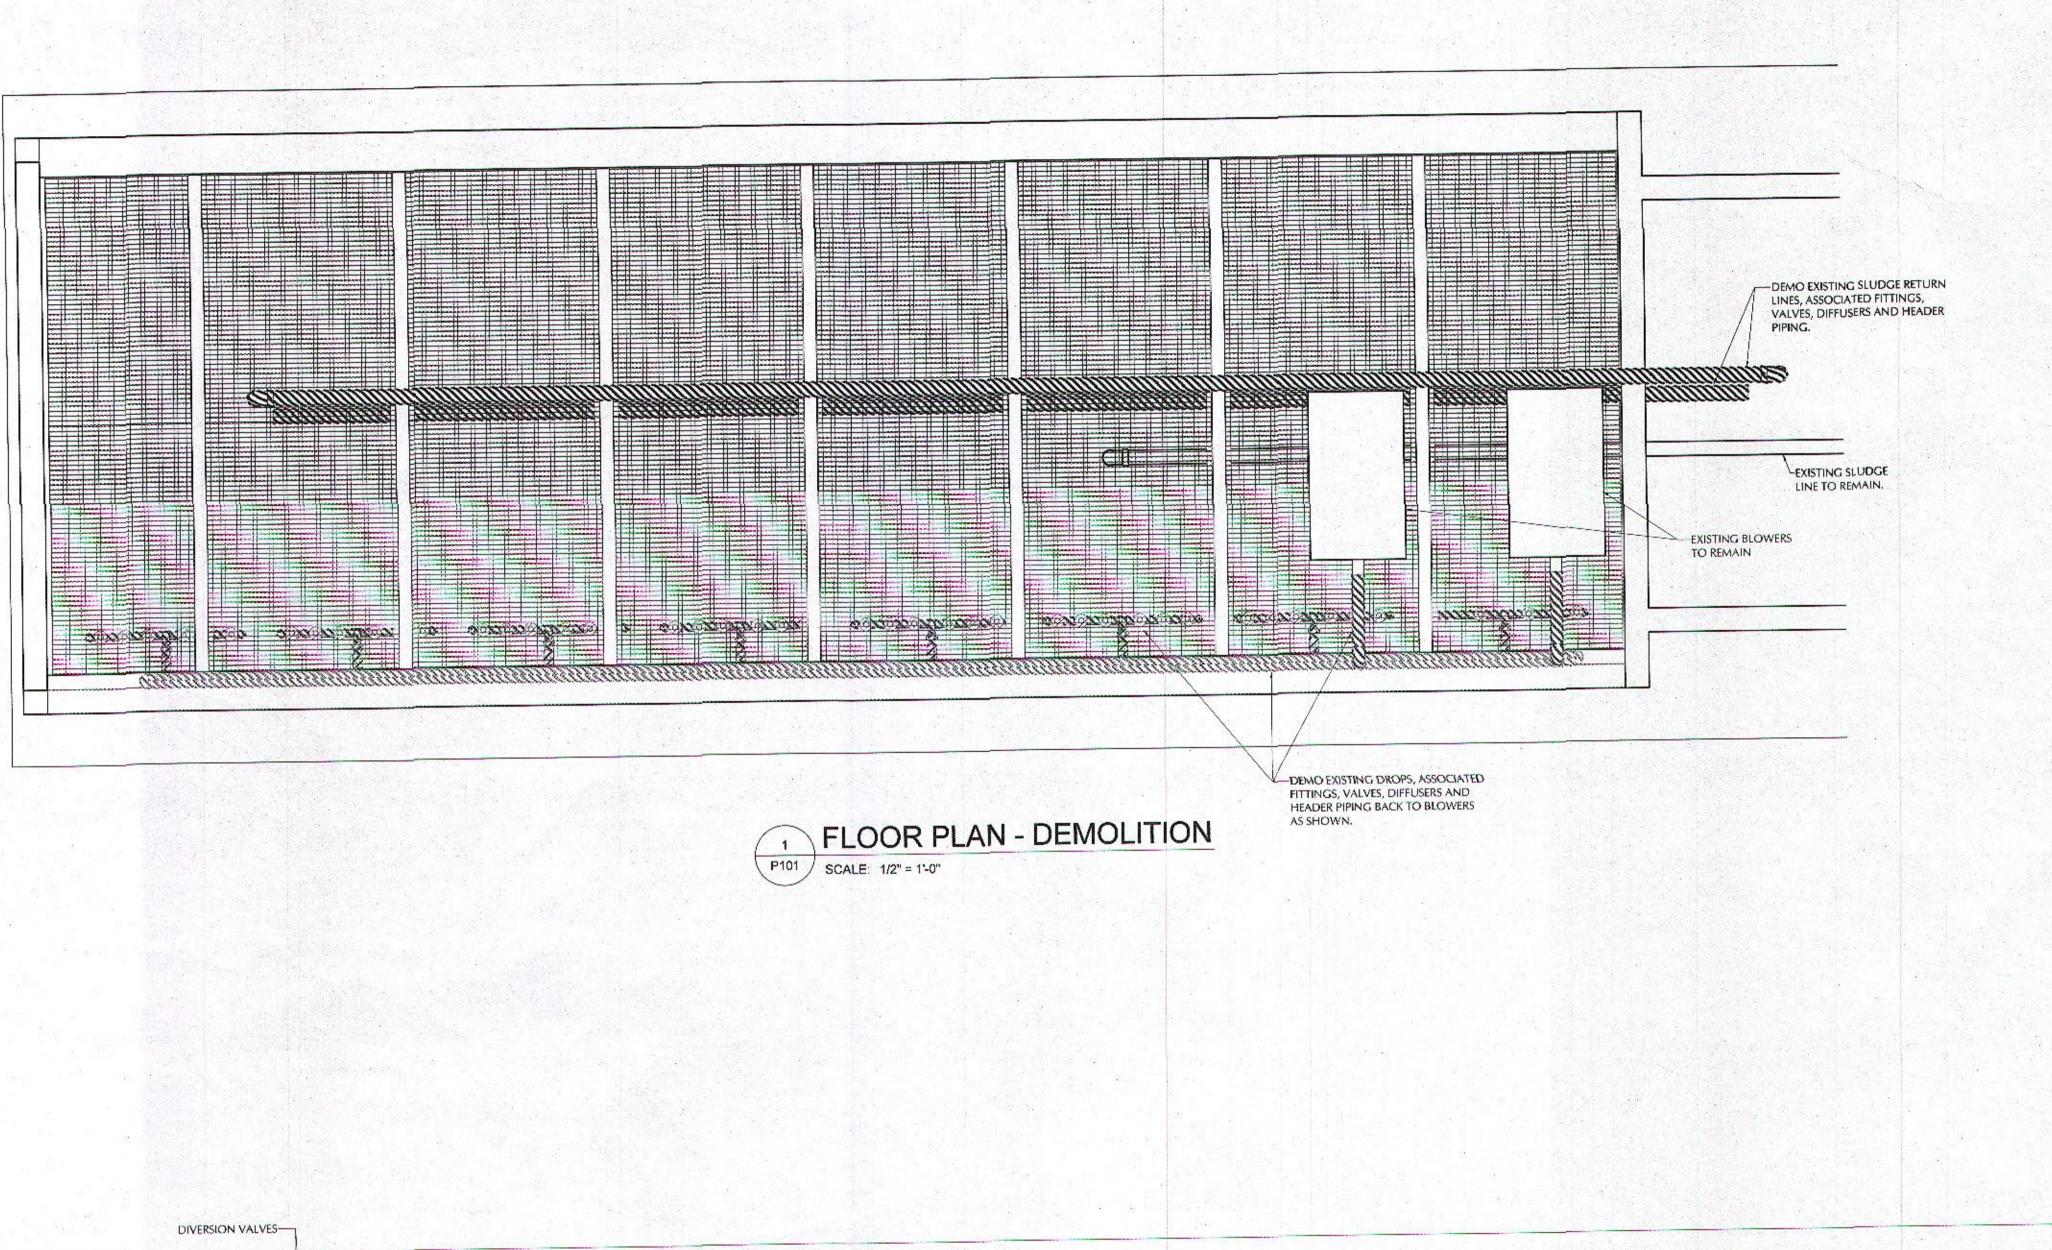

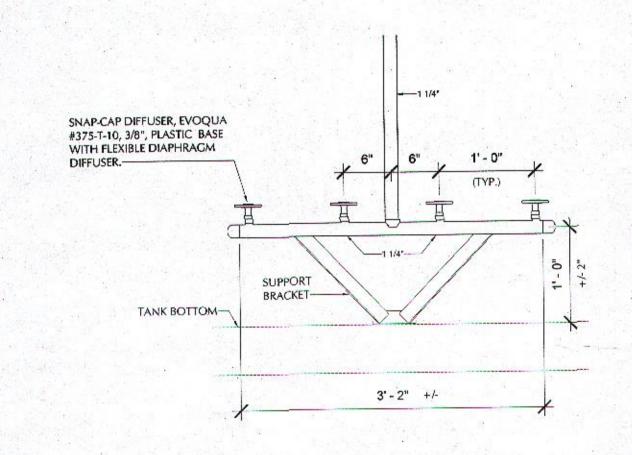


DIFFUSER HEADER ASSEMBLY DETAIL

SCALE: 1" = 1'-0"

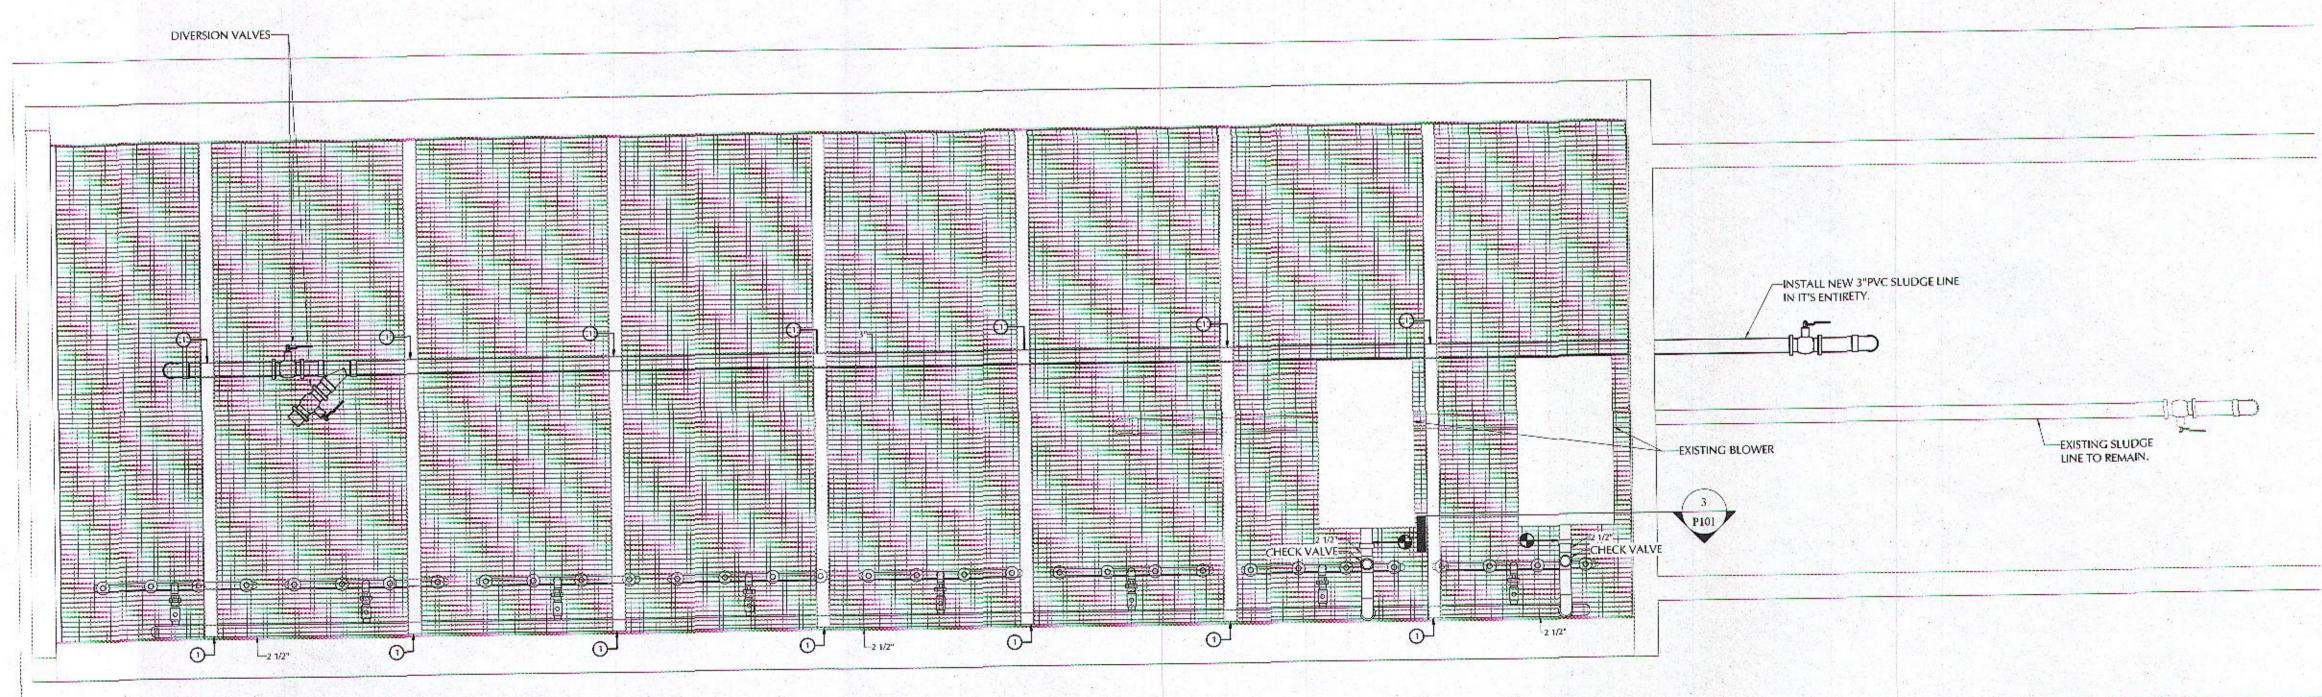


FLOOR PLAN - PIPING

P101 | SCALE: 1/2" = 1'-0"

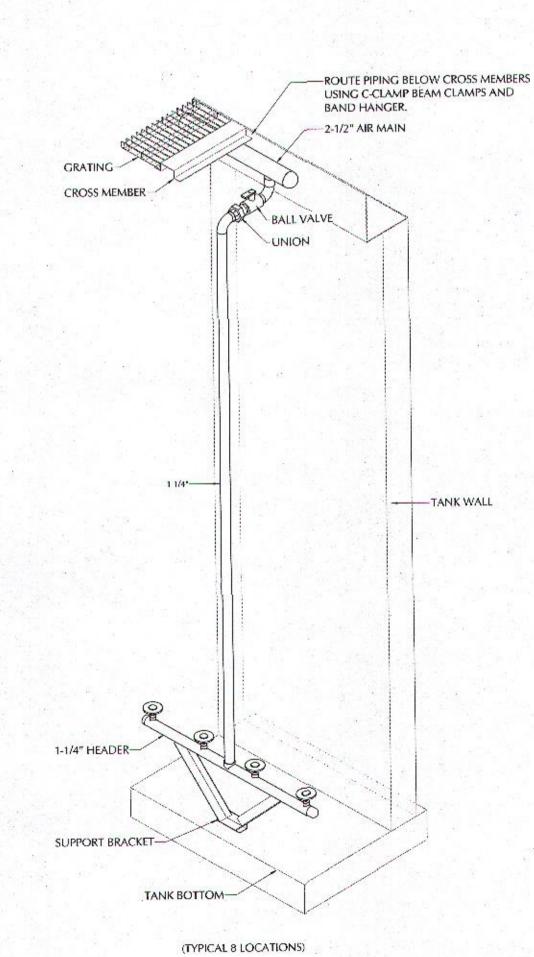

4 AIR PIPING DROP
SCALE: NTS

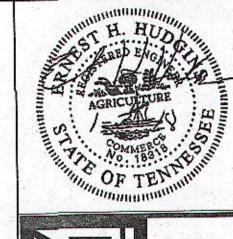



Midway Sewage Treatment Plant

DRAWING
TITLE...
FLOOR PLAN PIPING
SAOISIA

DRAWN
BY: CPB

CHECKED
BY: RWD

APPROVED

DATE: 01/02/18

PROJECT NO. 18533

DRAWING NO.

P101

	PLUMBING LEGEND	AS REED ENGLOS
SYM/ABB.	TYPE	TEM SULL
•	CONNECTION POINT (NEW TO EXISTING)	A CRICUITURE
	S PIPING FROM STEEL CROSS MEMBERS WITH C-CLAMP BEAM CLAMPS AND CHANGERS.	OP TENAMIN

Scope: furnish all labor, materials and equipment necessary for the installation of all plumbing work indicated on the drawings

inspection fees required by utility companies. Deliver to the owner certificates of inspections issued by the authorities.

B. All work shall be done in accordance with applicable city, county, and state ordinances and codes. The contractor shall make any minor adjustments to meet these requirements.

A. Pipe sizes (1/2-inch to 2-inch): Grade TP304 stainless steel, Schedule 10, ASTM A-182, VIC PRESS JOINTS.

B. Pipe sizes (2-1/2 inch to 8-inch): Grade TP304 stainless steel, schedule 40, ASTM A268-88A, VIC JOINTS.

Pipe in this article is available in NPS 1/8 to NPS 24 (DN 6 to DN 600).

B. PVC Socket Fittings: ASTM D 2467 for Schedule 80.

A. PVC Pipe: ASTM D 1785, Schedule 80.
Fittings in "PVC Socket Fittings" Paragraph below are available in NPS 1/8 to NPS 12 (DN 6 to DN 300).

A. Sizes (1/2-inch to 2-inch): Two piece brass body, stainless steel trim, reinforced Teffon seal and seats, large port, 720 PSI, threaded ends, Stockham S-217 or approved equal.

. Cleanouts: cleanouts for soil and waste lines shall be installed where indicated on drawings, and every 90 degrees change in direction. cleanouts shall also be placed every 100 feet outside

A. Make all water and air tests of the piping systems before

the top of vents or with 10 'head. should leaks appear, repair

B. As-built drawings: the plumbing contractor shall furnish upon completion of work a plumbing plan sepia showing all piping as

B. After the installation of sanitary piping, plug the ends of the system and fill with water to

and repeat the tests until the system is tight.

A. Obtain and pay for all permits, connection fees, and

as specified herein.

Permits, ordinances and inspections:

. STAINLESS PIPE AND FITTINGS - Air Line

. PVC PIPE AND FITTINGS - Sludge Line

. VALVES

A. Ball Valves:

1. Compressed Air:

or as indicated on drawings.

. Test and inspections:

installed.

work is concealed.



ewage

Midv Treat

NO.	DATE
70-	
DRAWN	
BY:	CPB
CHECKED	
BY:	RWD
APPROVED	
BY:	ЕНН
DATE:	01/02/18

DRAWING NO.

PROJECT NO. 18533

P201